


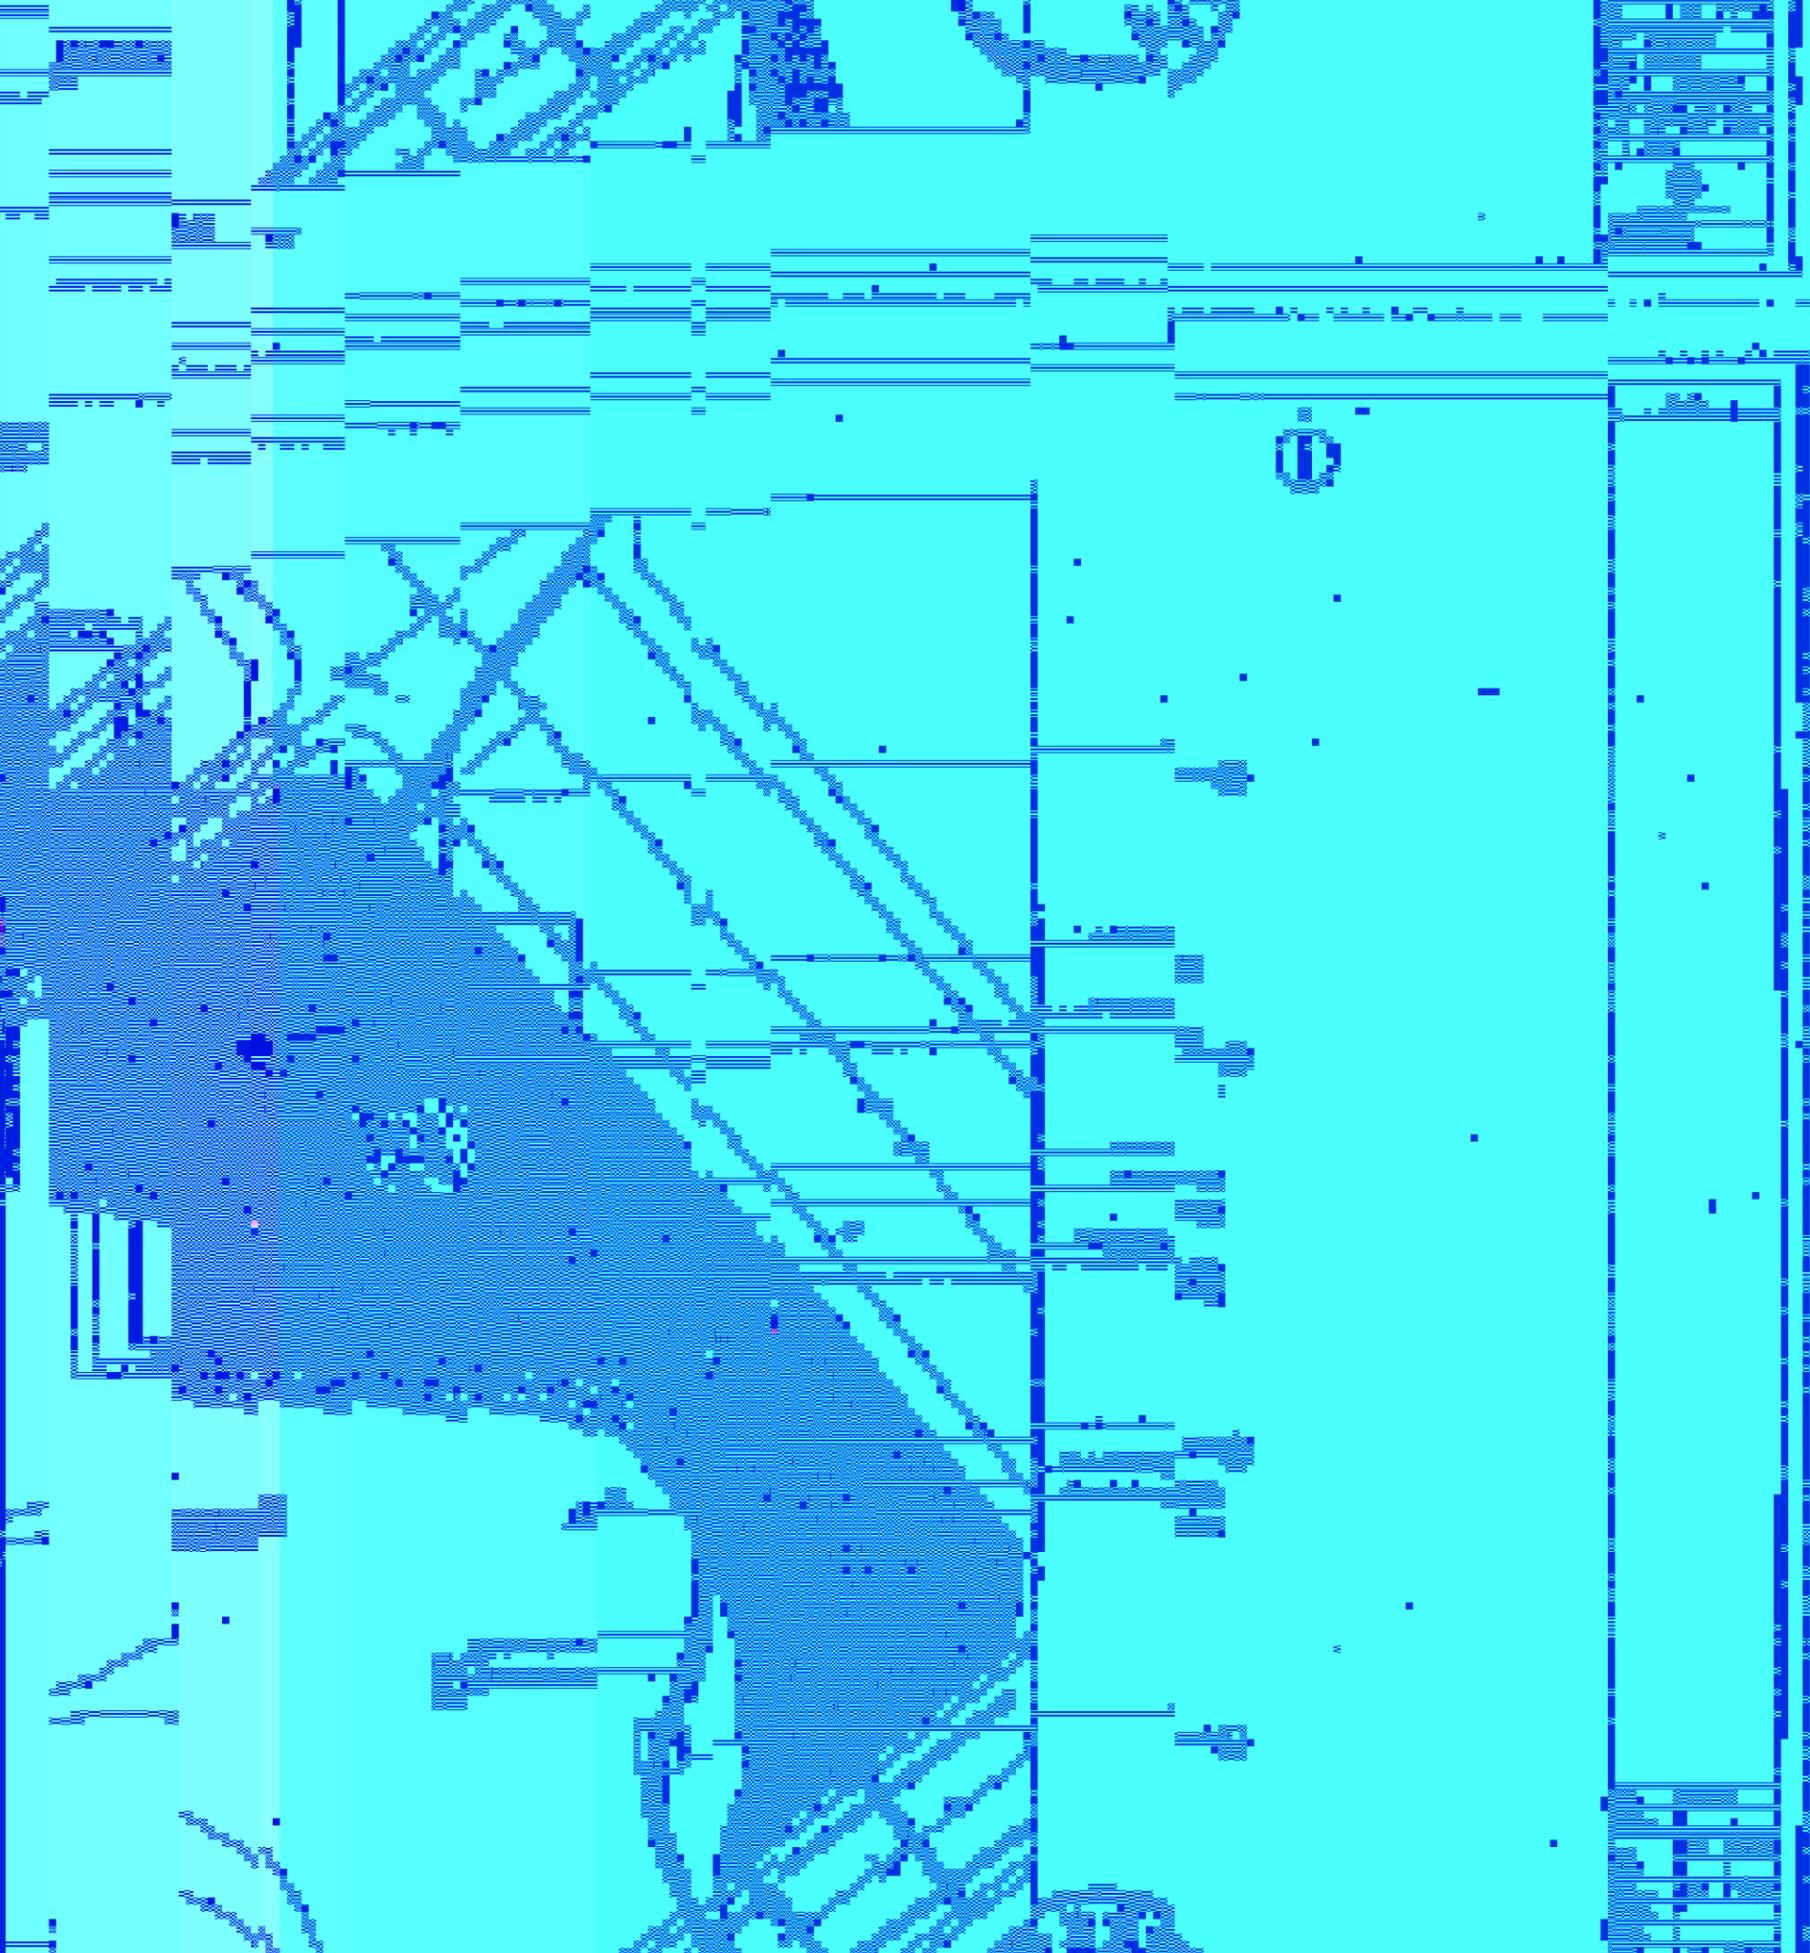
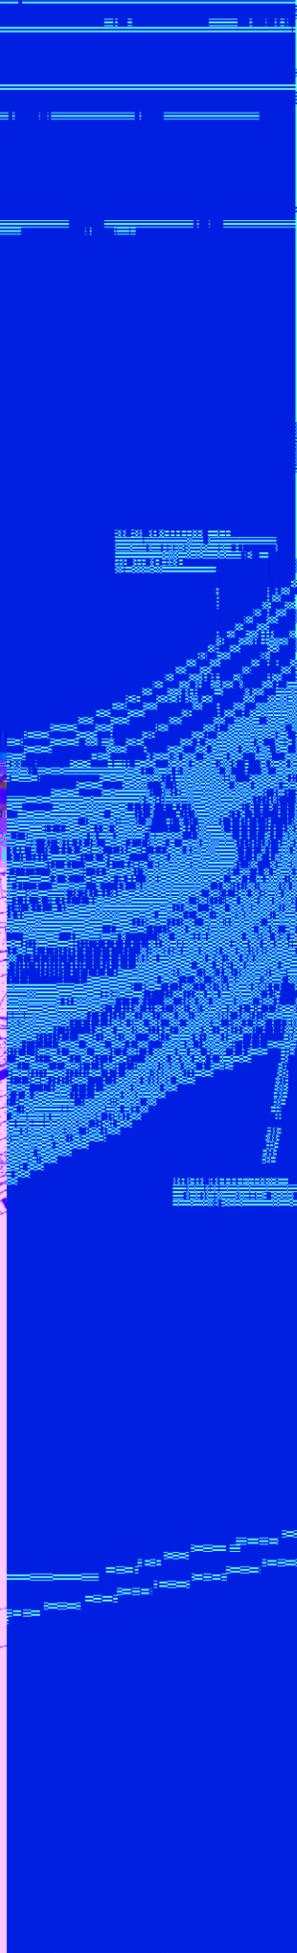


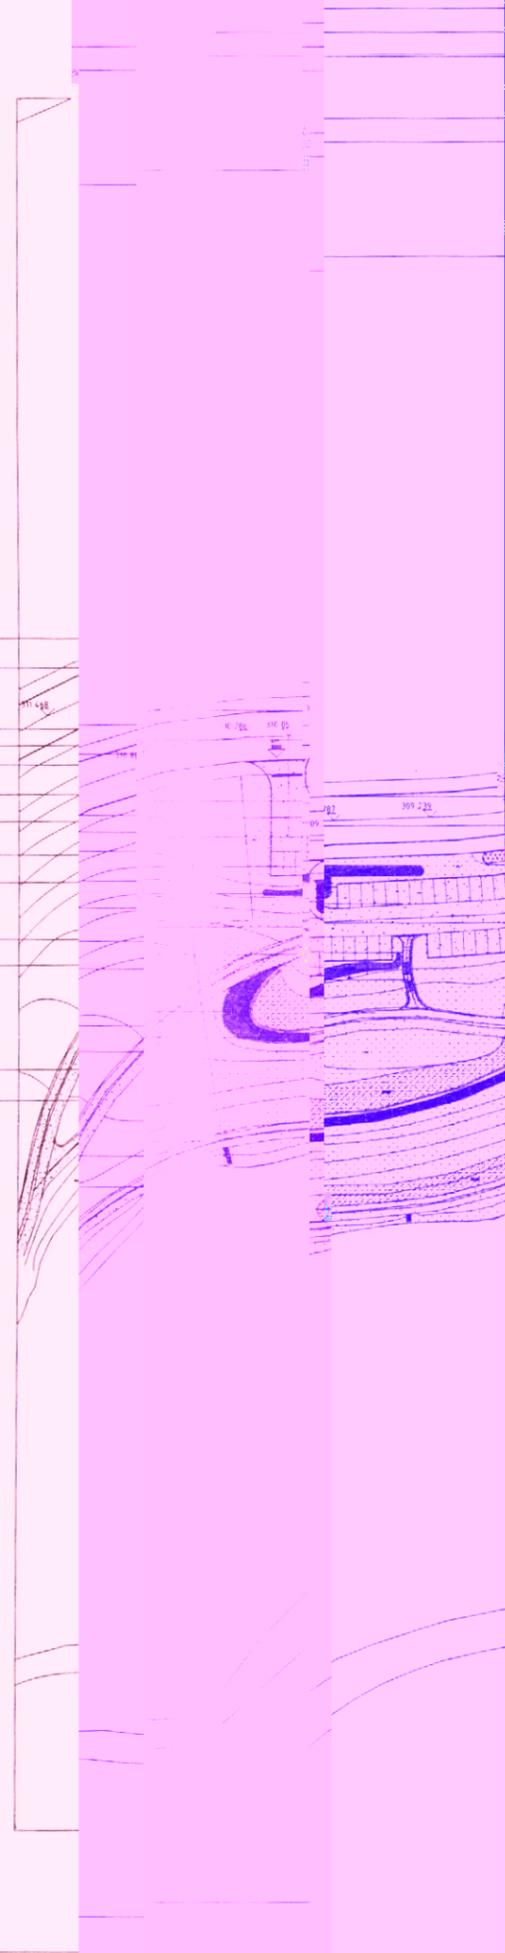


- 1. 结构工程
- 2. 建筑
- 3. 给排水
- 4. 暖通
- 5. 电气
- 6. 弱电
- 7. 消防
- 8. 人防
- 9. 其他

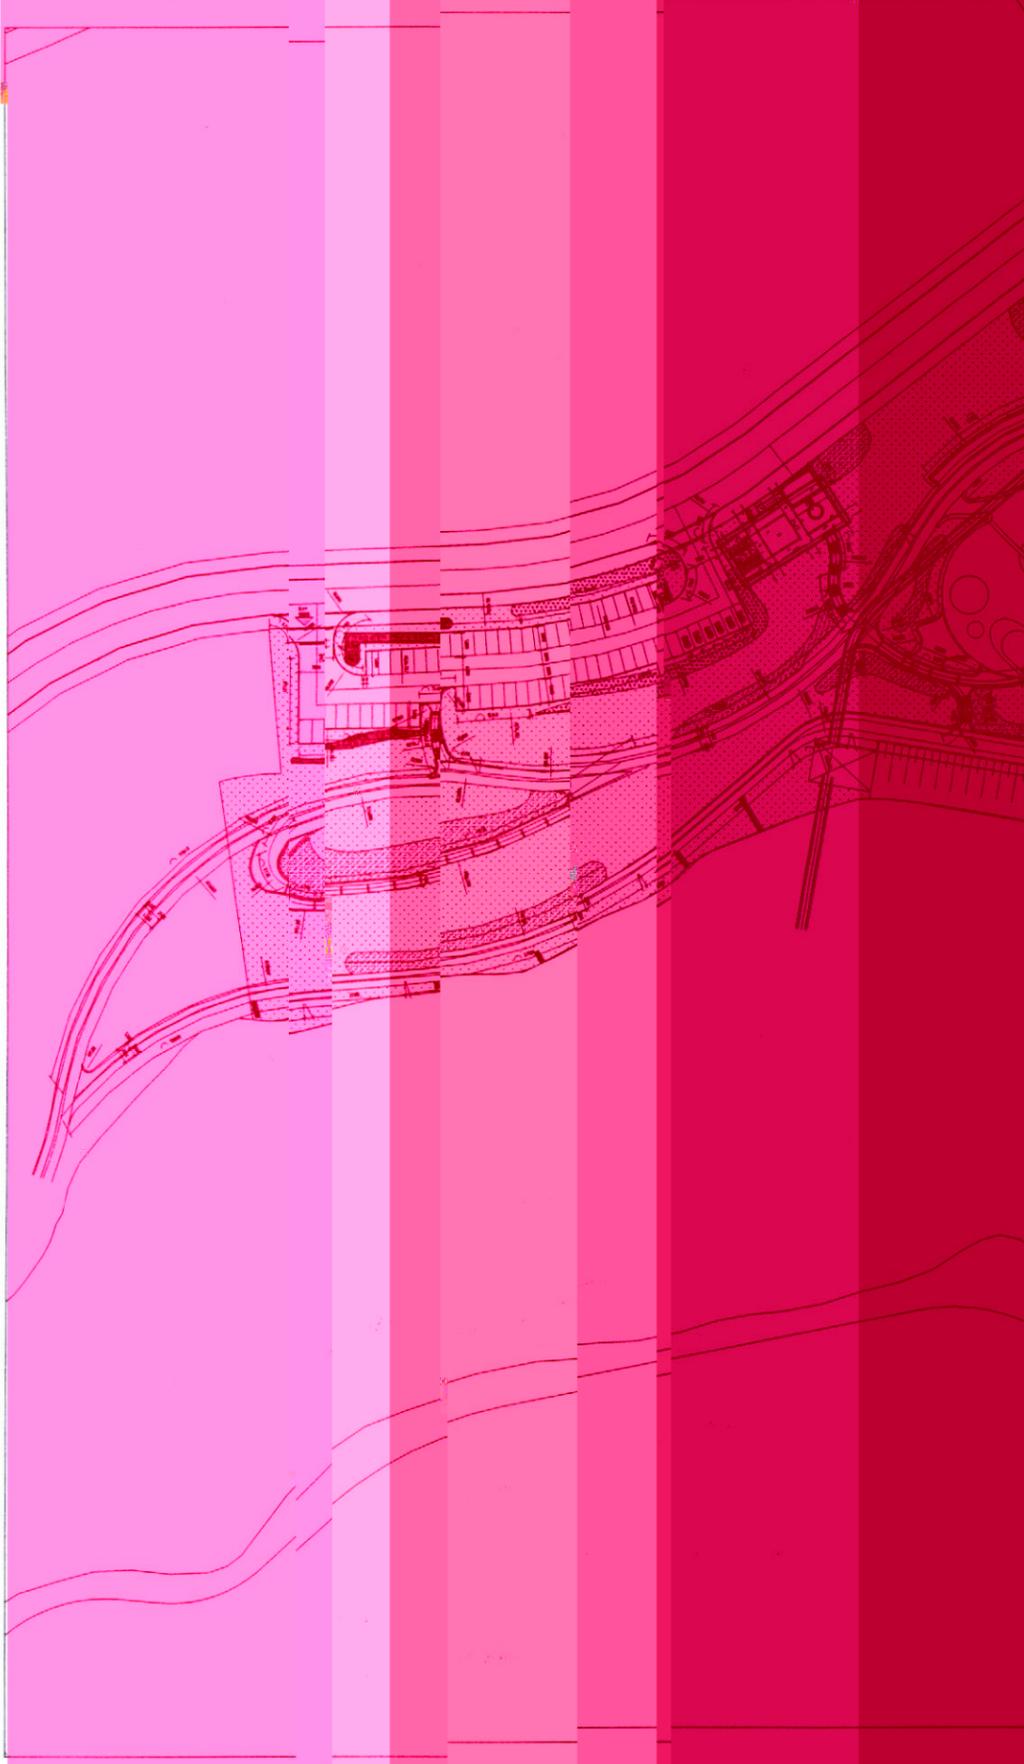

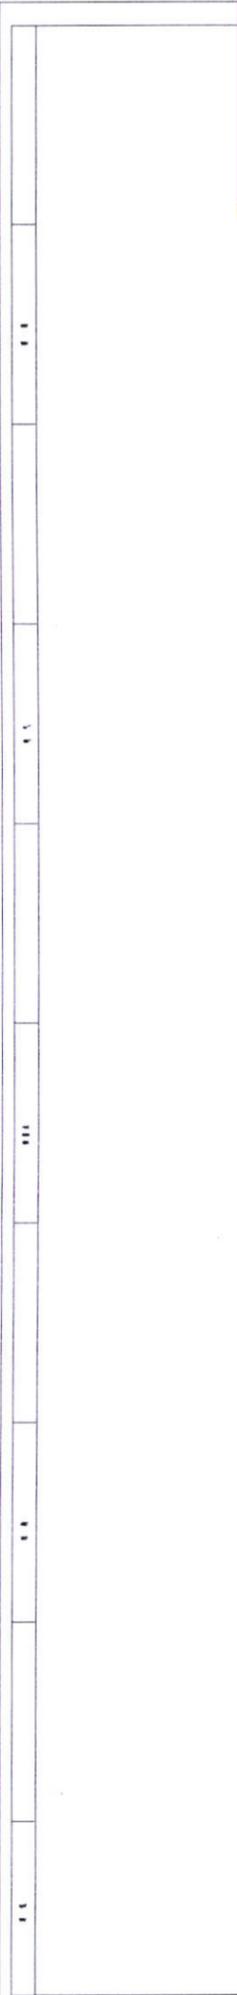

① 儿童乐园尺寸总平面图

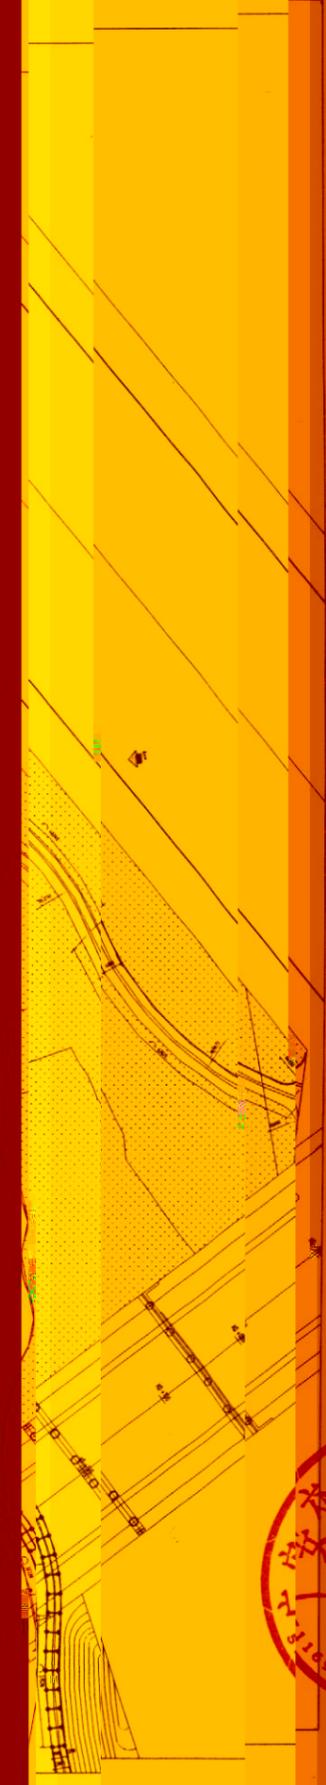

图名	儿童乐园尺寸总平面图
图号	
比例	1:100
日期	2023.03
设计	
审核	
制图	
校对	
绘图	
审核	
日期	2023.03







